

Elevation A

Elevation B



Elevation C

Venesta Active Lockers


Elevation D

Elevations (1:20)

NOTE: To be read in conjunction with the following drawings: 7570_04_001 Proposed Plan 7570_04_002 Proposed Sections 7570_04_010 Proposed Indicative electrical layout drawing 7570_04_011 Proposed door & window schedule (sheet 1)

7570_04_011 Proposed door & window schedule (sheet 1) 7570_04_012 Proposed door & window schedule (sheet 2) 7570_10_02 Indicative finishes/specifications - Canteen


and Proposed Finishes Schedule

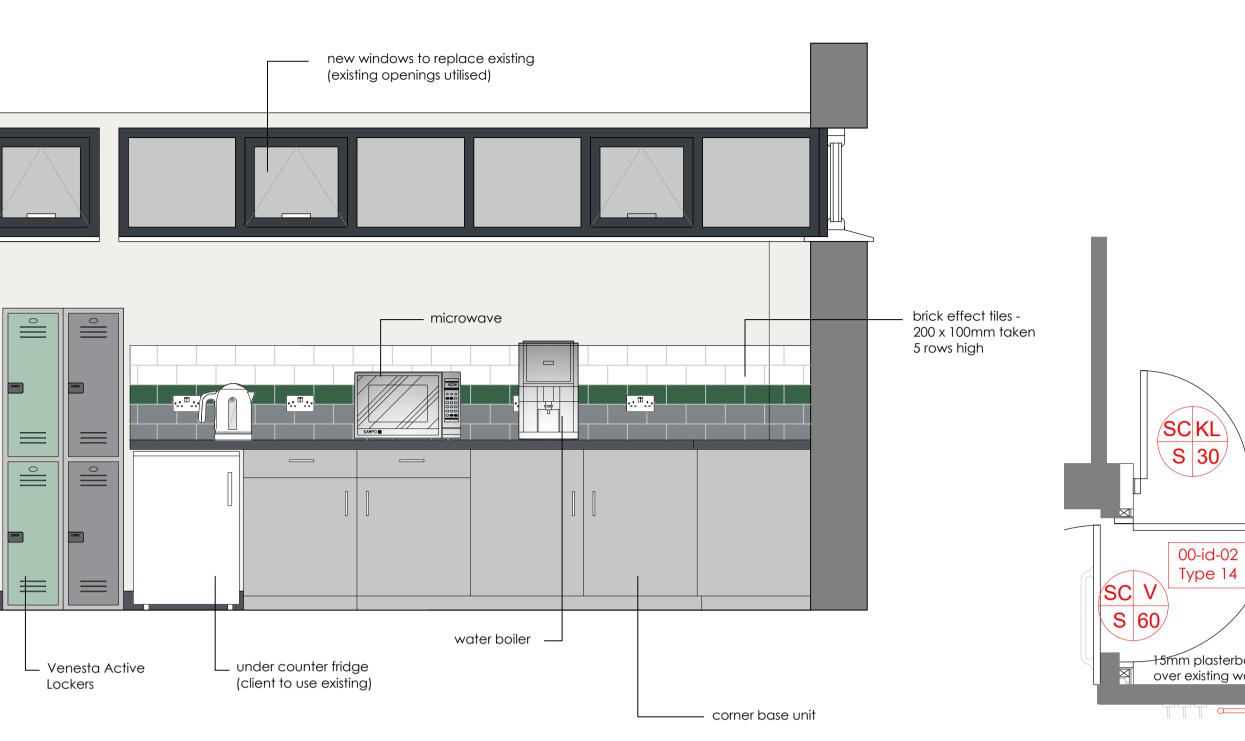



COPYRIGHT NOTICE: This drawing is the copyright of the Architects and may not be reproduced or used except by written permission.

©Crown copyright and database rights(2014) Ordnance Survey licence number100047514
Notes
This drawing is to be read in conjunction with all relevant drawings and specifications.
Do not scale from this drawing, Use figured dimensions only. All levels and dimensions to be checked on site. All
level and dimensional discrepancies are to be bought to the immediate attention of HSSP Architects tid.
Responsibility cannot be accepted for alteration and/or deviation from HSSP Architects tid.
Copyright reserved. This drawing, may only be used for the client and location specified in the title block. It may not
be copied ar disclosed to any other third party without prior wither consent from HSSP Architects tid.
All work to be to the entire satisfaction of the NHBC or Local Authority not withstanding anything shown or
indicated on these drawing. All workmanship and materials to be the best of their respective kind and at dest
equivalent of the appropriate Bitlids Standard Code of Practice. All relevant dimensions and levels to be
accented and verified on site before specification/employers requirements and structural engineers

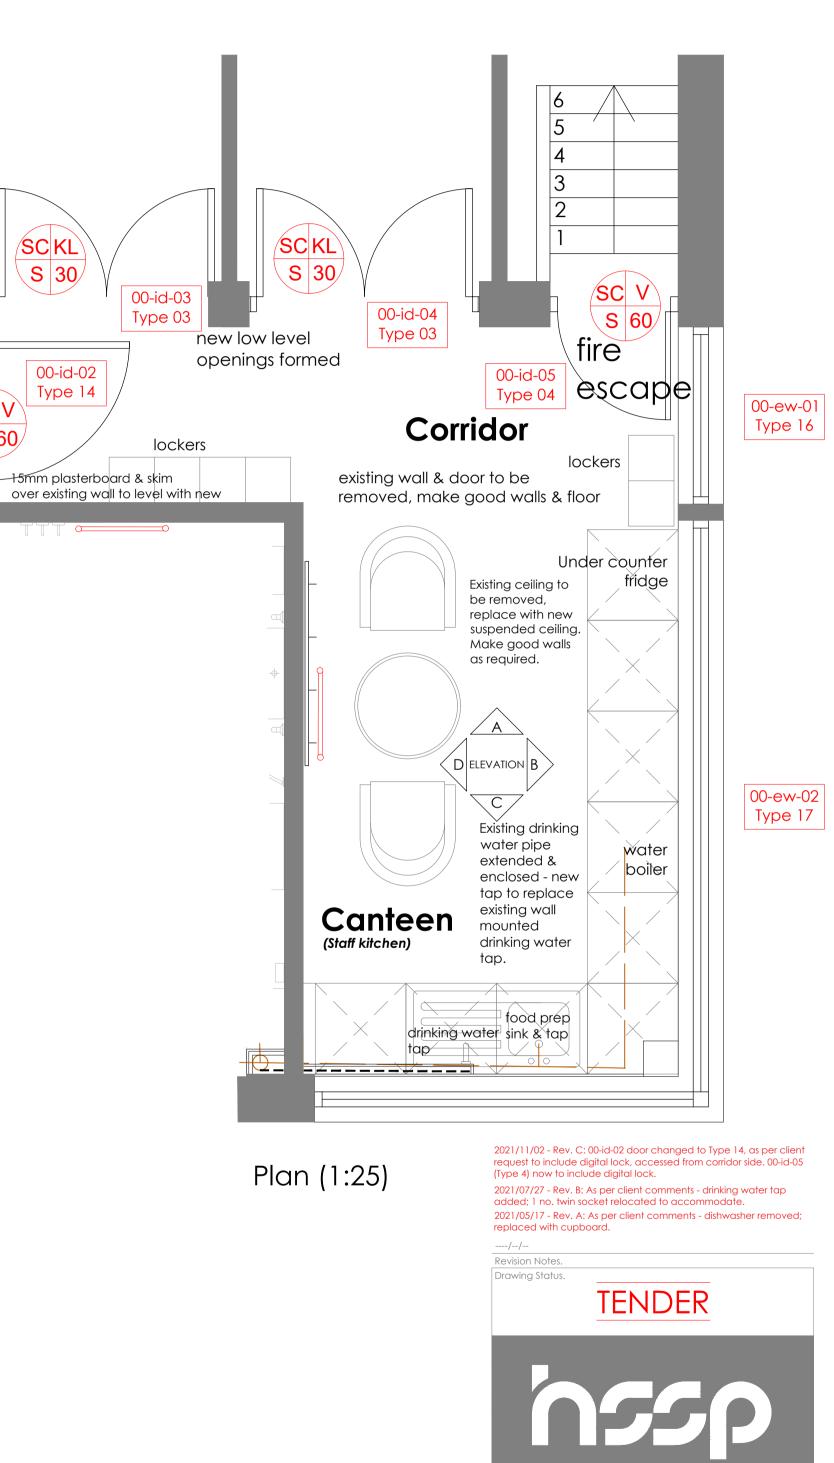

architectsPera Business Park, Nottingham Road
Melton Mowbray, LE13 OPBTelephone: 01664 563 288
E-Mail: info@hssparchitects.co.ukFax: 01664 563 360
Web: www.hssparchitects.co.ukProject.Proposed Internal Alterations
Braunstone Civic Centre
209 Kingsway, Braunstone
for Braunstone Town Council

Indicative Room Layout - Canteen

Scale. Drawn. Checked. Date.

 I:20 / I:25
 KES
 April 2021

 Drawing No.
 7570_04_014
 C

HSSP A1